
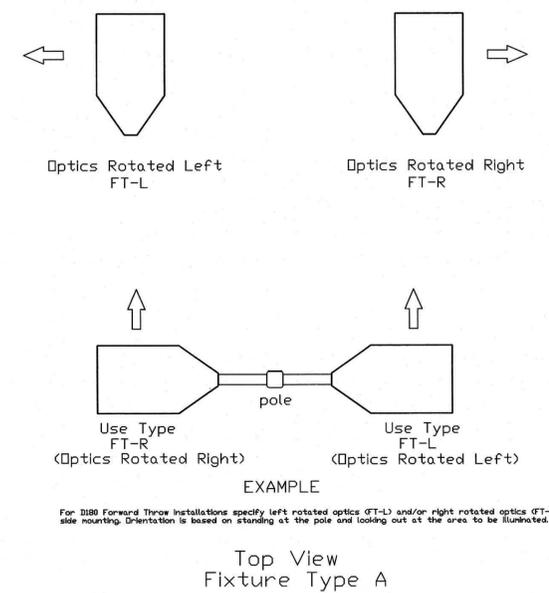


VICINITY MAP  
NTS

Luminaire Schedule									
Symbol	Qty	Label	Arrangement	Description	LLD	UDF	LLF	Arr. Lum. Lumens	Arr. Watts
	5	A	D180° 2RTD	SLM-LED-24L-SIL-(1)FT-L; (1)FT-R-50-70CRI-D180-22*POLE+2*BASE	1.000	1.000	1.000	31770	377.6
	4	B	SINGLE	XWM-FT-LED-06L-50 MTD @ 10'	1.000	1.000	1.000	5936	44.7

Calculation Summary							
Label	CalcType	Units	Avg	Max	Min	Avg/Min	Max/Min
ALL CALC POINTS	Illuminance	Fc	2.27	14.8	0.0	N.A.	N.A.
INSIDE CURB	Illuminance	Fc	6.34	14.8	0.8	7.93	18.50

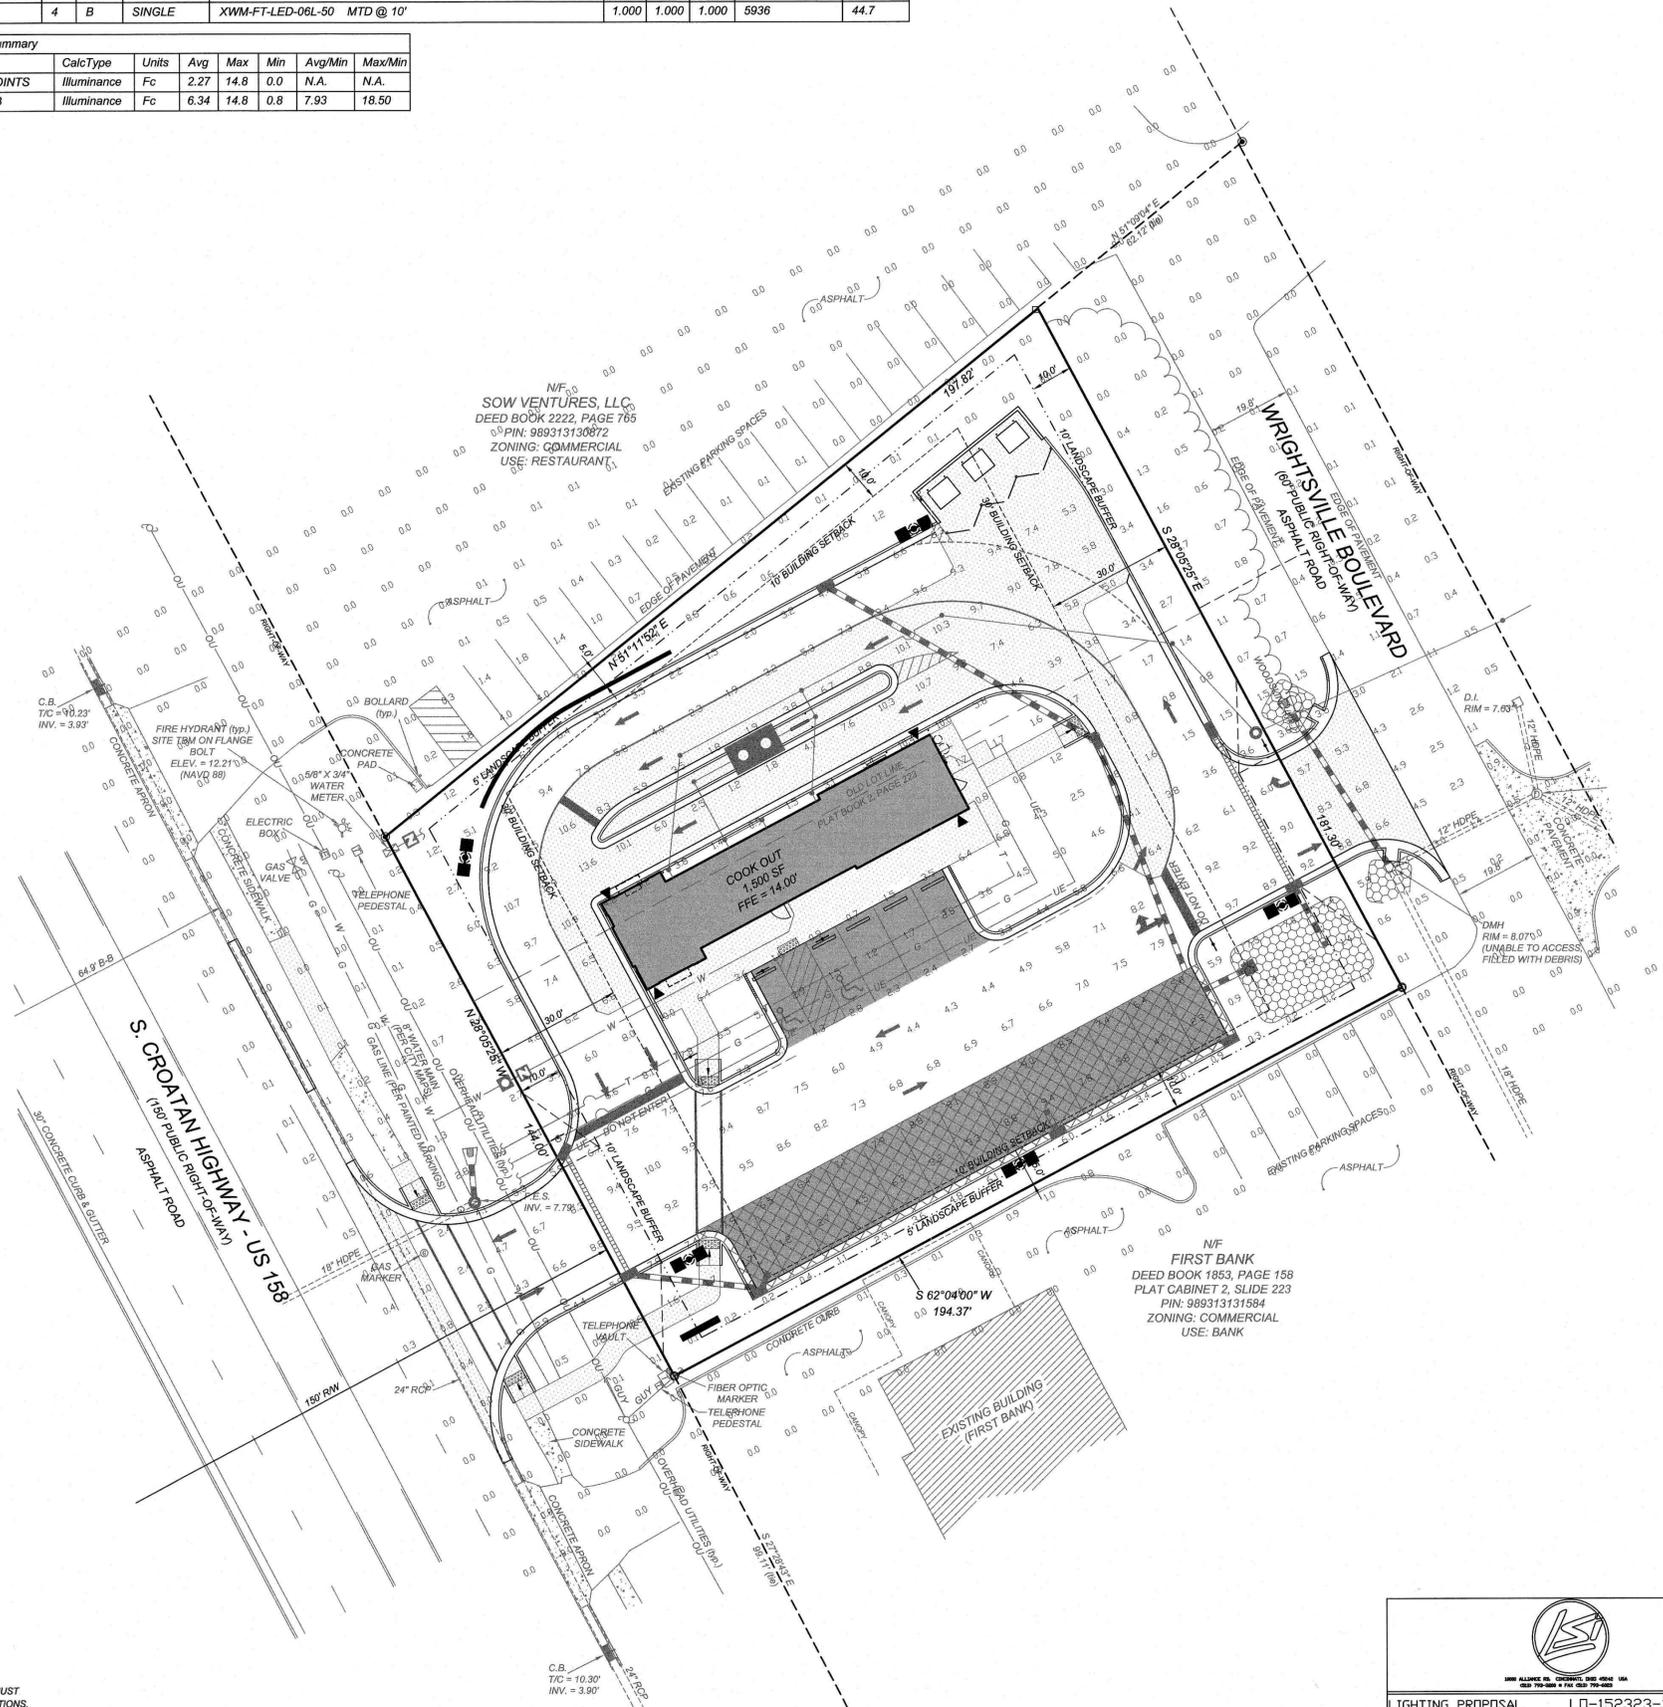

BASED ON THE INFORMATION PROVIDED, ALL DIMENSIONS AND LUMINAIRE LOCATIONS SHOWN REPRESENT RECOMMENDED POSITIONS. THE ENGINEER AND/OR ARCHITECT MUST DETERMINE THE APPLICABILITY OF THE LAYOUT TO EXISTING OR FUTURE FIELD CONDITIONS.

THIS LIGHTING PLAN REPRESENTS ILLUMINATION LEVELS CALCULATED FROM LABORATORY DATA TAKEN UNDER CONTROLLED CONDITIONS IN ACCORDANCE WITH THE ILLUMINATING ENGINEERING SOCIETY (IES) APPROVED METHODS. ACTUAL PERFORMANCE OF ANY MANUFACTURER'S LUMINAIRES MAY VARY DUE TO CHANGES IN ELECTRICAL VOLTAGE, TOLERANCE IN LAMP/SLED'S AND OTHER VARIABLE FIELD CONDITIONS. CALCULATIONS DO NOT INCLUDE OBSTRUCTIONS SUCH AS BUILDINGS, CURBS, LANDSCAPING, OR ANY OTHER ARCHITECTURAL ELEMENTS UNLESS NOTED. FIXTURE NOMENCLATURE NOTED DOES NOT INCLUDE MOUNTING HARDWARE OR POLES. THIS DRAWING IS FOR PHOTOMETRIC EVALUATION PURPOSES ONLY AND SHOULD NOT BE USED AS A CONSTRUCTION DOCUMENT OR AS A FINAL DOCUMENT FOR ORDERING PRODUCT.

 
**811**  
Know what's below.  
Call before you dig.  
nc811.org or 1-800-632-4949

LIGHTING PROPOSAL LD-152323-1

COOKOUT  
S CROATAN HWY  
KILL DEVIL HILLS, NC

DATE: 09-22-20 REV: 10-29-20 SHEET 1 OF 1

SCALE: 1"=20'



NO	DATE	DESCRIPTION	BY
1	10-26-20	TOWN COMMENTS	DDH

**COMMERCIAL SITE DESIGN**

8872 CREEKWOOD ROAD  
RALEIGH, NORTH CAROLINA 27615

(919) 848-4371 FAX: (919) 848-3741  
WWW.CSDESIGN.COM

CLIENT/OWNER:  
COOKOUT  
15 LAURA LANE, SUITE 300  
THOMASVILLE, NC 27386  
TELEPHONE: (336) 215-7025  
FAX: (336) 474-1849

**COOKOUT FRESH HAMBURGERS**

2005 S CROATAN HIGHWAY  
KILL DEVIL HILLS, NORTH CAROLINA

**LIGHTING PLAN**

PROJECT NO.	OUT-2022
FILENAME	OUT2022-LI
DRAWN BY:	DDH
SCALE:	1"=20'
DATE:	09-04-2020
SHEET NO.	C-9

X:\OUT - Cookout\2022 - Kill Devil Hills, NC\CAD\OUT2022-LI.dwg, 11/2/2020 11:46:18 AM, chhen