




REVISIONS	
NO.	DESCRIPTION


LIGHTING PLAN
JOLLY ROGER RESTAURANT
VIRGINIA DARE TRAIL (NC 12)
 NORTH CAROLINA
 DARE COUNTY
 ATLANTIC TOWNSHIP
 KILL DEVIL HILLS

DATE:	12/14/2021
SURVEYED:	SEE NOTES
DESIGNED:	JMD
DRAWN:	KCA
CHECKED:	JMD
FILE:	04354L

SCALE:
1" = 20'
C203
 PROJ. NO. 04354L

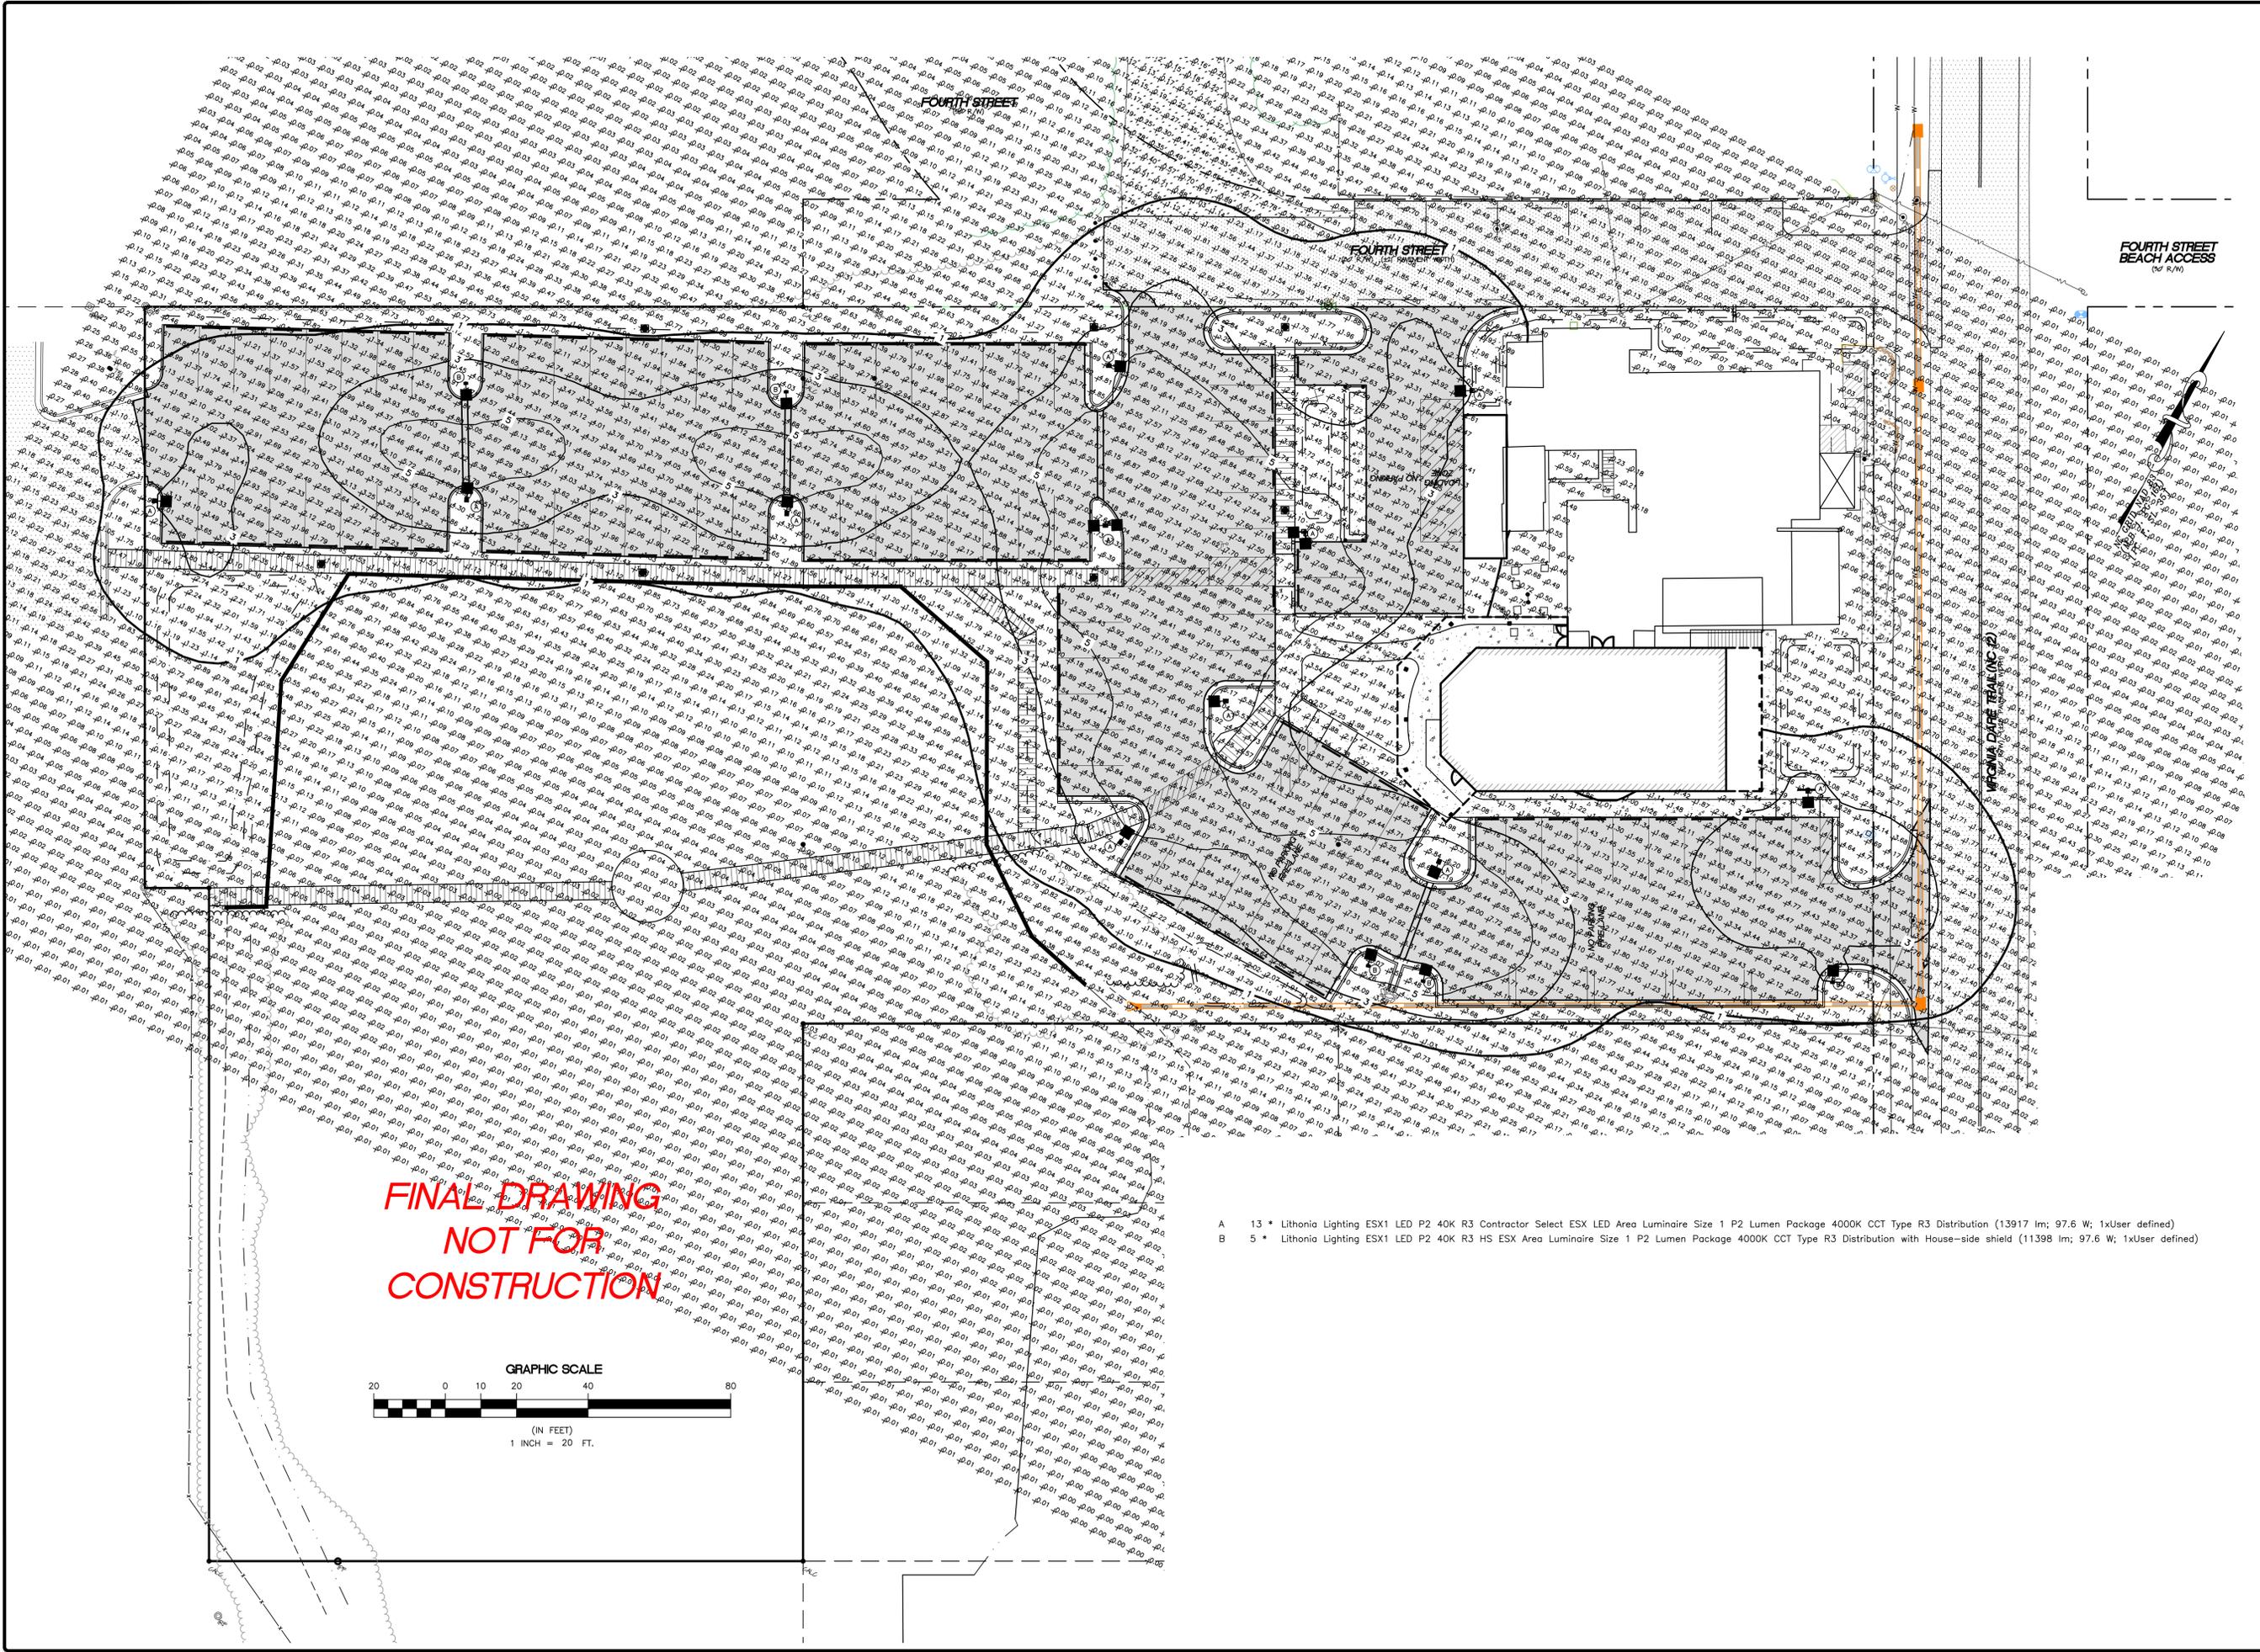

FINAL DRAWING
NOT FOR
CONSTRUCTION

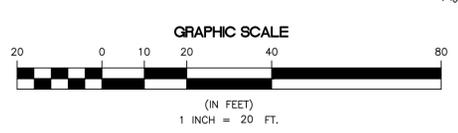

- A 13 * Lithonia Lighting ESX1 LED P2 40K R3 Contractor Select ESX LED Area Luminaire Size 1 P2 Lumen Package 4000K CCT Type R3 Distribution (13917 lm; 97.6 W; 1xUser defined)
- B 5 * Lithonia Lighting ESX1 LED P2 40K R3 HS ESX Area Luminaire Size 1 P2 Lumen Package 4000K CCT Type R3 Distribution with House-side shield (11398 lm; 97.6 W; 1xUser defined)