


**NOTE REGARDING WATER SERVICE LINE AND METER SIZING**

The Architect shall provide the water meter sizing form for each of the unit models and the pool amenity to determine if the 5/8x3/4 service is adequately sized for the units. Normally a four or five bedroom unit would only require a 5/8x3/4 service, but these units are all provided with full baths in each suite and several amenity fixtures that may require higher demand and larger services.

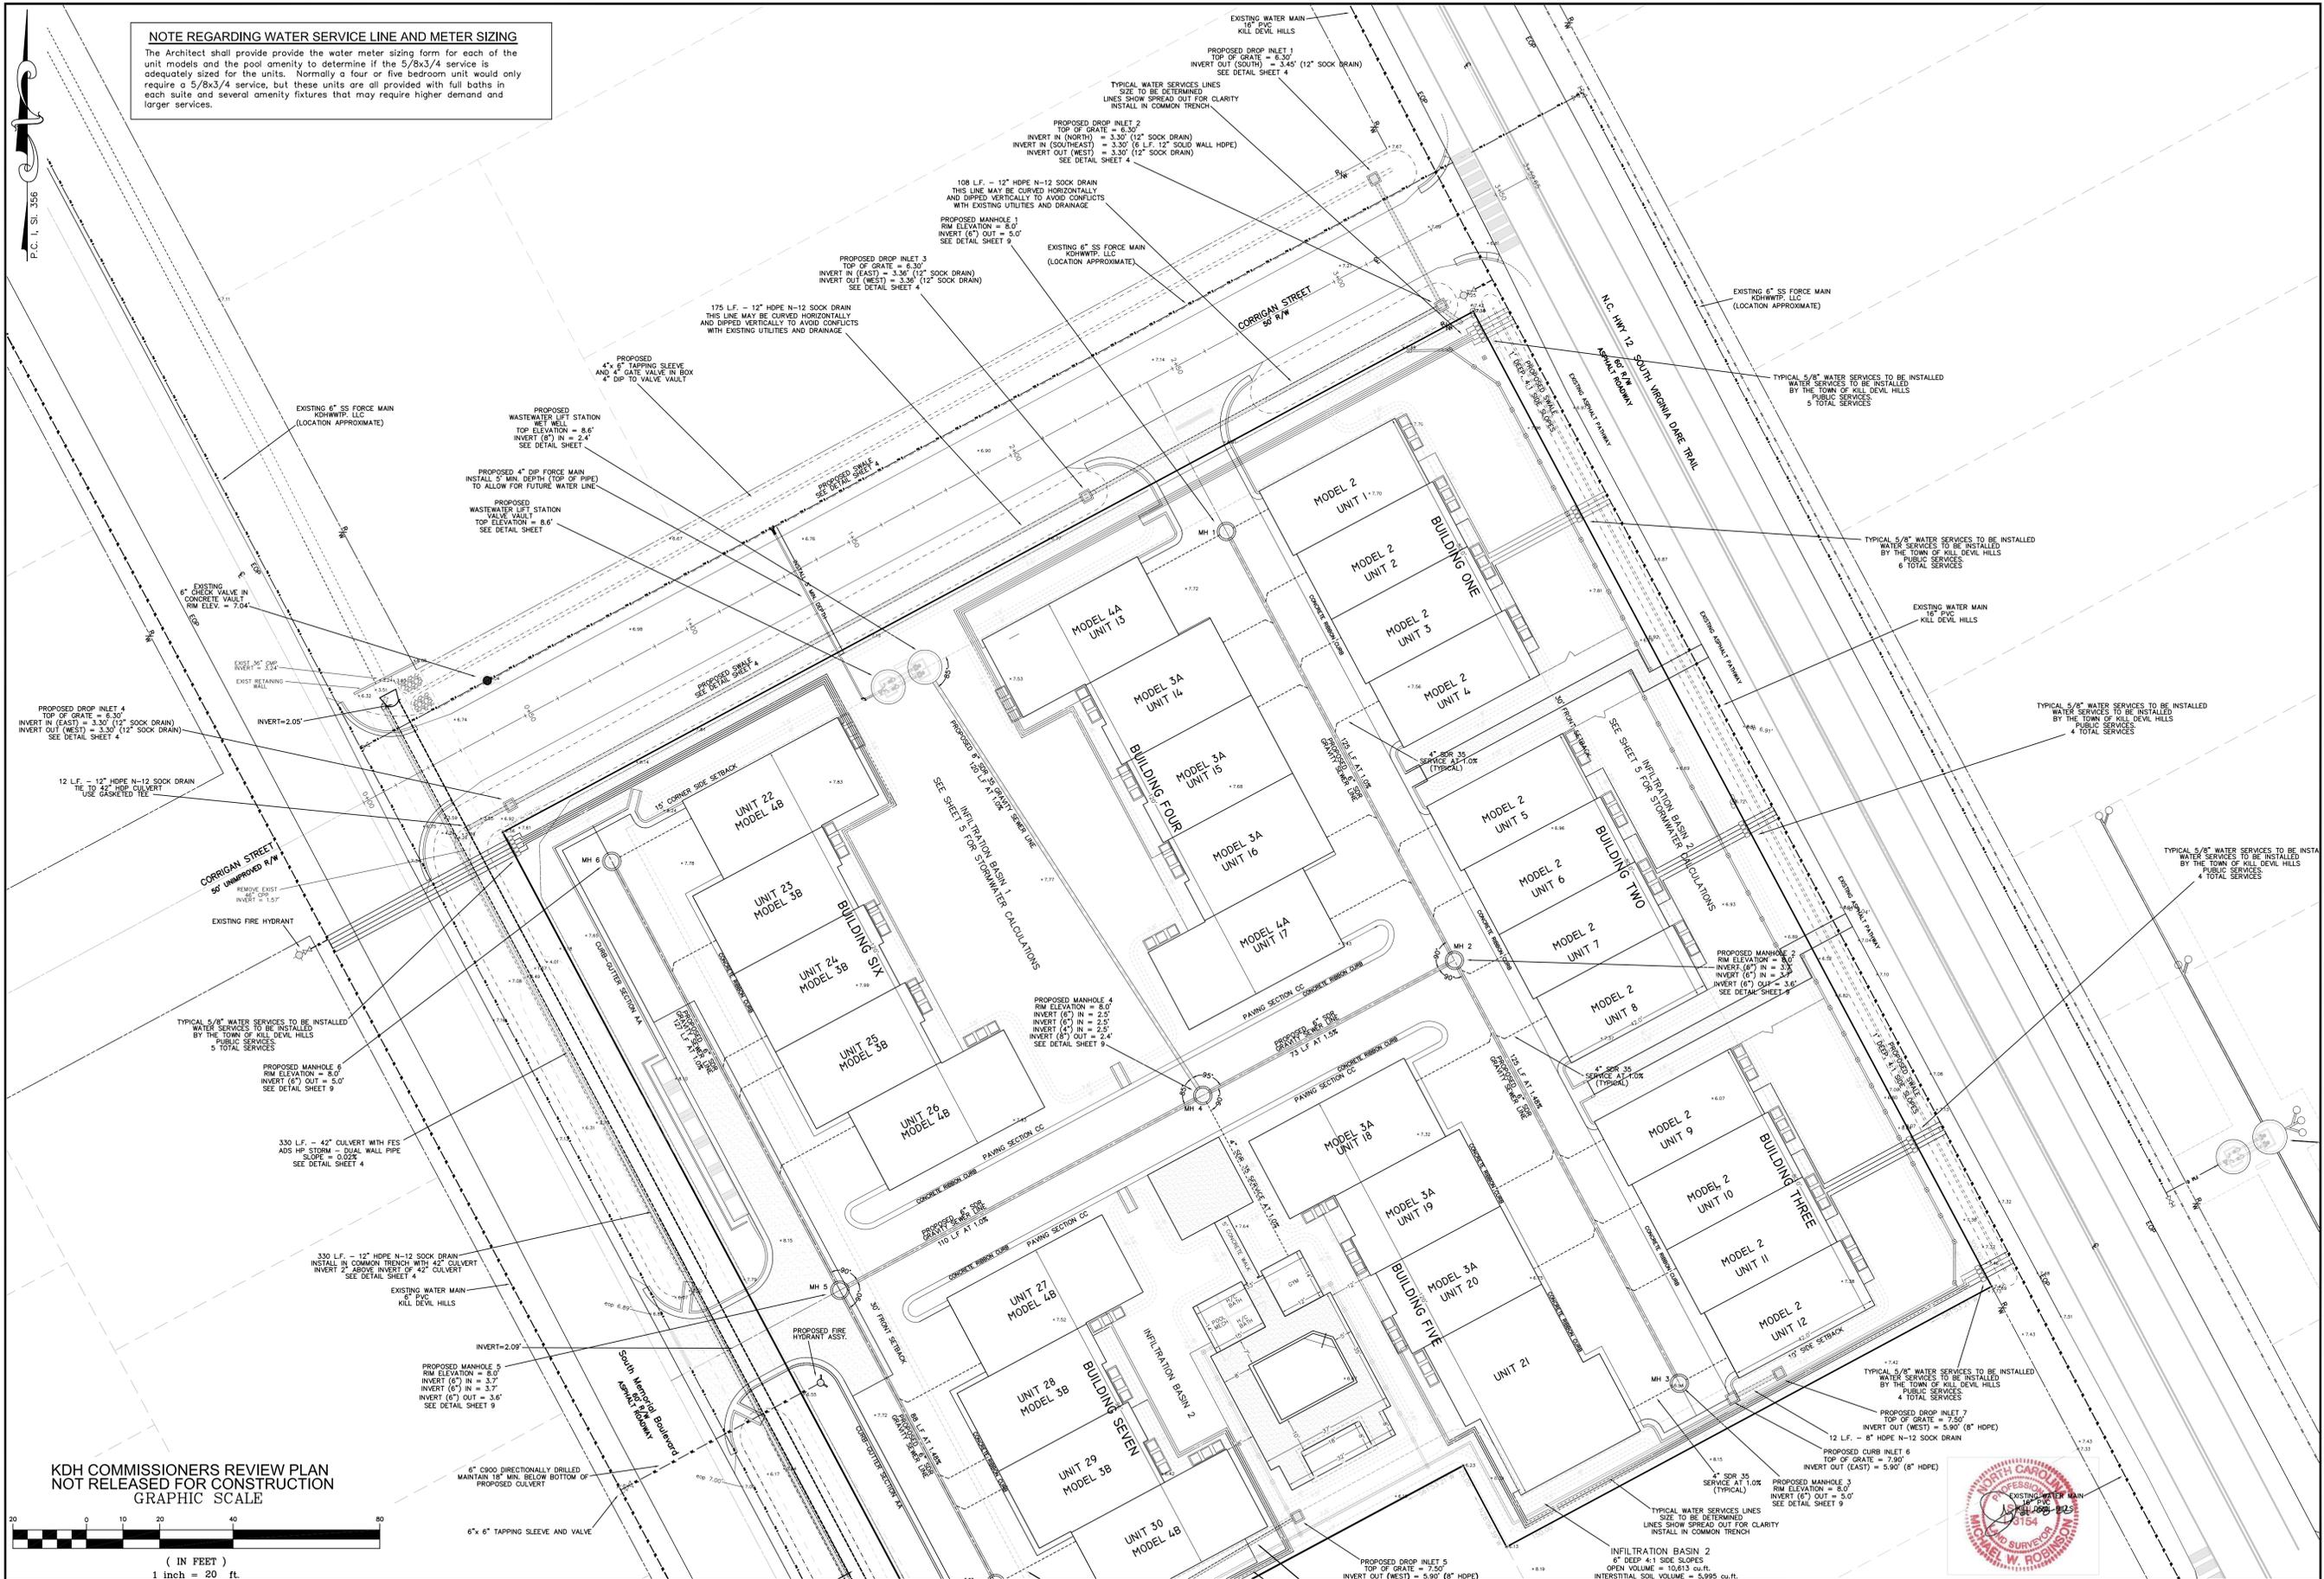

**MICHAEL W. ROBINSON, P.E., P.L.S.**  
**ENGINEERING AND SURVEYING**  
 P.O. BOX 2852  
 KILL DEVIL HILLS, NC 27948  
 PHONE: 252-255-8026  
 EMAIL: mrobinson@bwengineering.com

**UTILITY PLAN**



NO.	DATE	DESCRIPTION	BY	CHKD.
1	02-22-22	REV FOR PERMITS/REVISED	MWR	

**OCEAN BREEZE TOWNHOMES**  
 NORTH CAROLINA  
 DARE COUNTY  
 KILL DEVIL HILLS  
**902 SOUTH VIRGINIA DARE TRAIL**

DATE: 01-31-22 SCALE: 1"=20'  
 DESIGNED: MWR DRAWN: MWR  
 SHEET: 2A OF 10  
 CAD FILE: ocean view cottages-kill-devil.dwg  
 PROJECT NO: 051121

